






NOTE:  
1. All measurements are in feet and inches.

Description
 Wall
 Column
 Window
 Beam Line

KEY PLAN

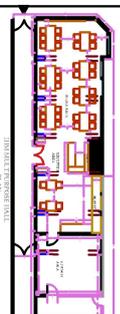


REV.	DATE	DESCRIPTION


Client:  
**Institute of Hotel Management,**  
Dadar west,  
Mumbai.

CONSULTANT:  


Drawing Title: <b>IHM MULTIPURPOSE HALL</b> Plan			
Scale	Sheet 01	Date: 17.03.2025	
Drawn by: ANAYKUNYA SHORRE	Checked by: CAJIBANAG YOKA	Approved by:	Scale: 1/8"=1'-0"
Sheet No: 03	Revision:		

# IHM MULTIPURPOSE HALL PLAN

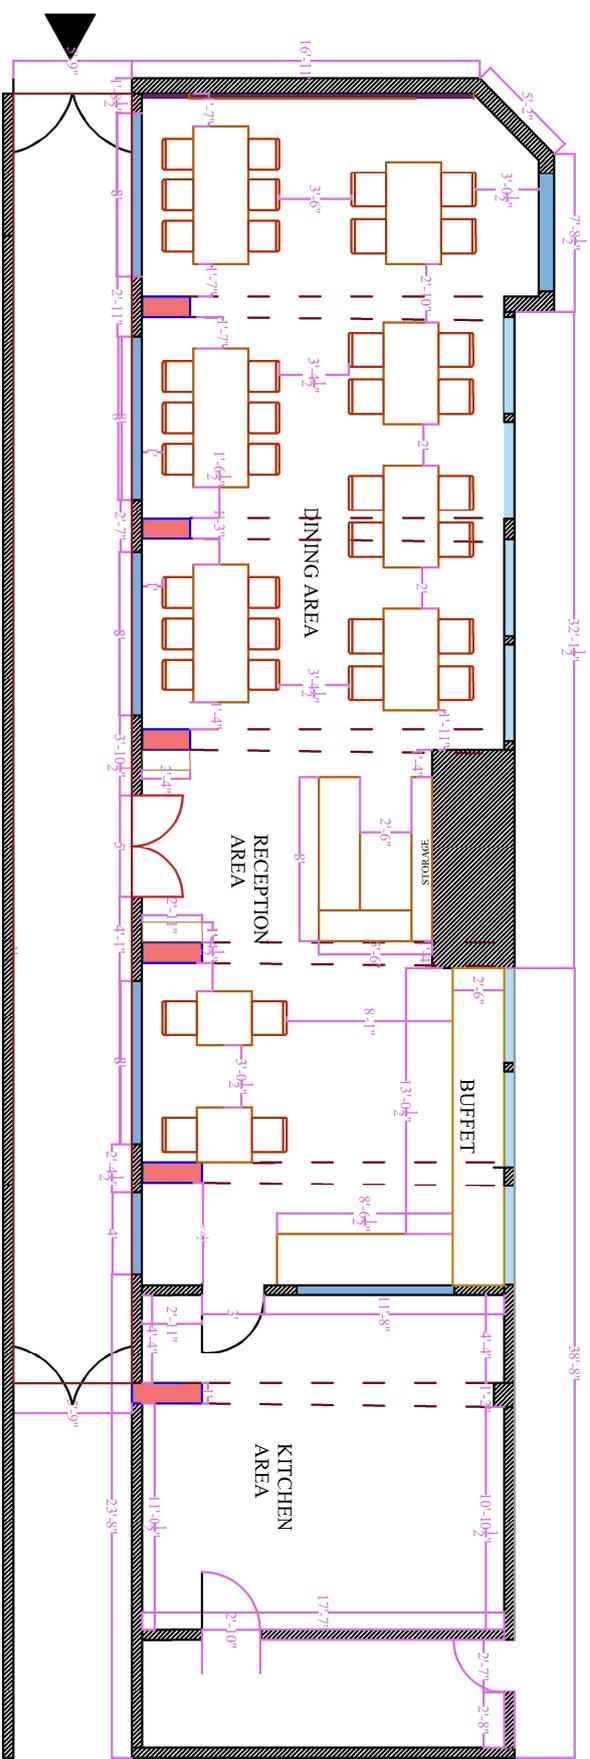

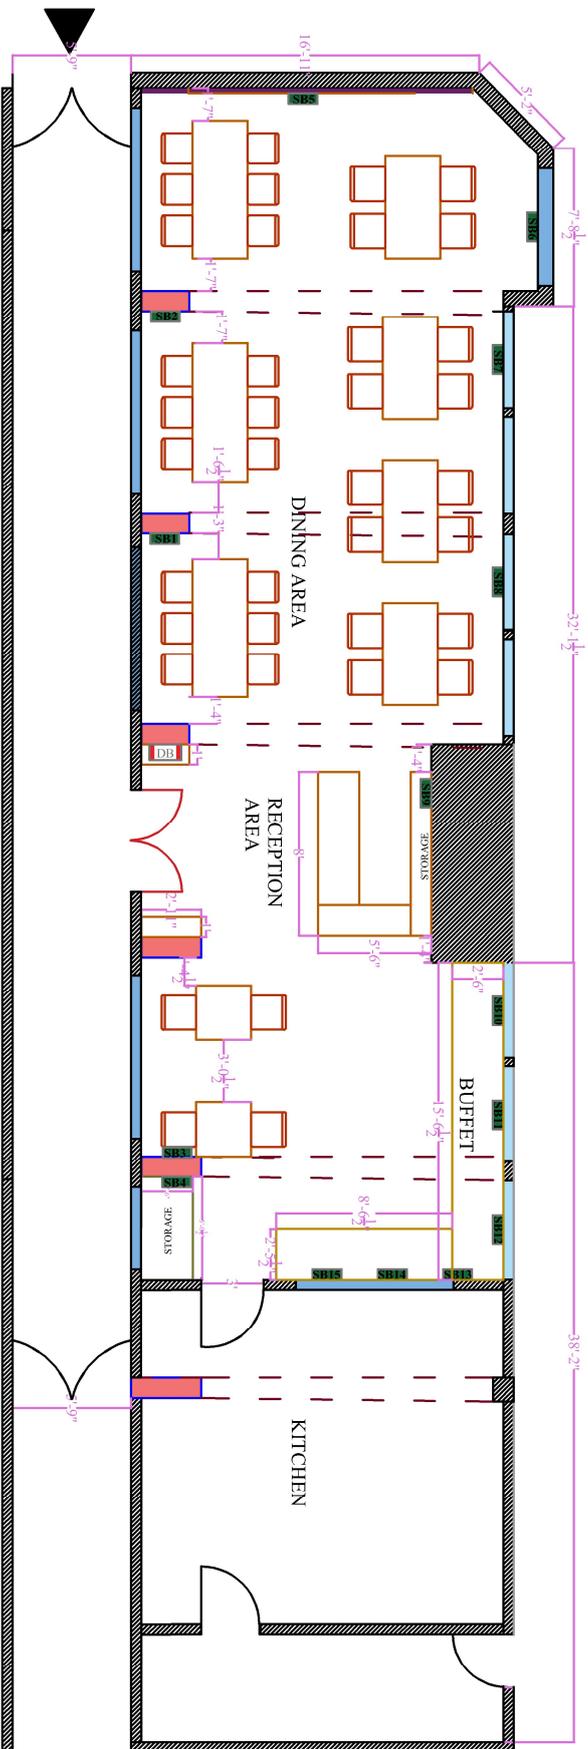


**IHM MULTIPURPOSE HALL**  
**SB LAYOUT**  
**Switchboard schedule**

<b>SB1</b> 4 Module		<b>SB7</b> 4 Module		<b>SB13</b> 6 Module	
<b>SB2</b> 4 Module		<b>SB8</b> 4 Module		<b>SB14</b> 6 Module	
<b>SB3</b> 4 Module		<b>SB9</b> 6 Module		<b>SB15</b> 6 Module	
<b>SB4</b> 4 Module		<b>SB10</b> 6 Module			
<b>SB5</b> 6 Module		<b>SB11</b> 6 Module			
<b>SB6</b> 4 Module		<b>SB12</b> 6 Module			

**NOTE:**  
1. All measurements are in feet and inches.

Description	
	Wall
	Column
	Window
	Beam Line

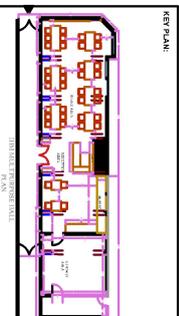

REV.	DATE	DESCRIPTION

**Institute of Hotel Management,**  
Dadar west,  
Mumbai.



Drawing Title: **IHM MULTIPURPOSE HALL**  
SB PLAN

Scale	Drawn by	Checked by	Approved by	Date of Issue	Revision


Sheet No. **03**





NOTE  
1. All measurements are in feet and inches.

Description	
	Wall
	Column
	Window
	Beam Line

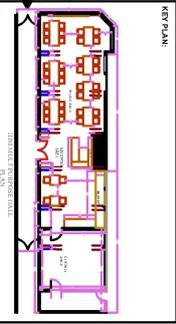


REV.	DATE	DESCRIPTION


Client:  
**Institute of Hotel Management,**  
Dadar west,  
Mumbai.



Drawing Title:			
IHM MULTIPURPOSE HALL			
Elevation A - A'			
Scale:	Sheet No:	Task:	Revision:
1" = 1'-0"	05	17. DESIGN	03
Drawn by:	Checked by:	Approved by:	
ANAYIKHA MISHRA	CAJIBANOV YOKA		
Sheet No:			
03			

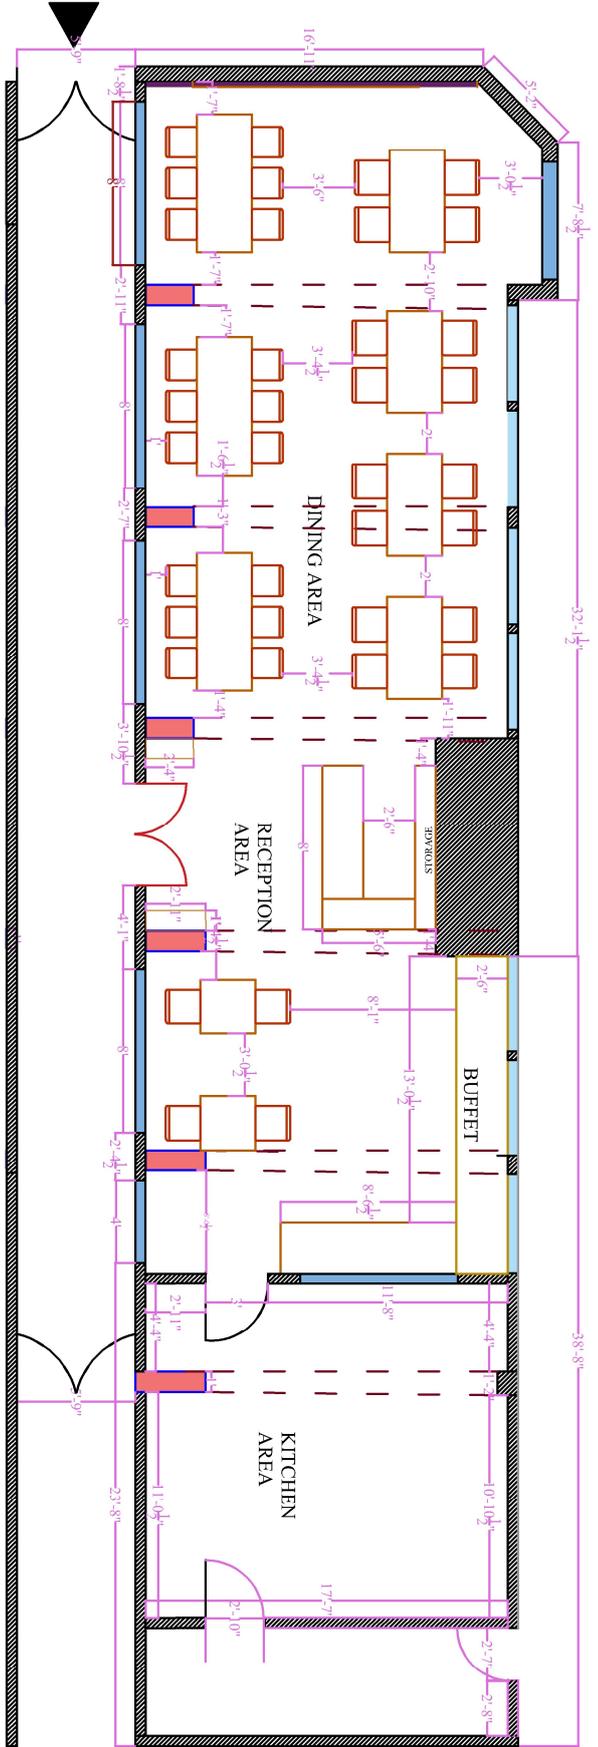

## IHM MULTIPURPOSE HALL PLAN

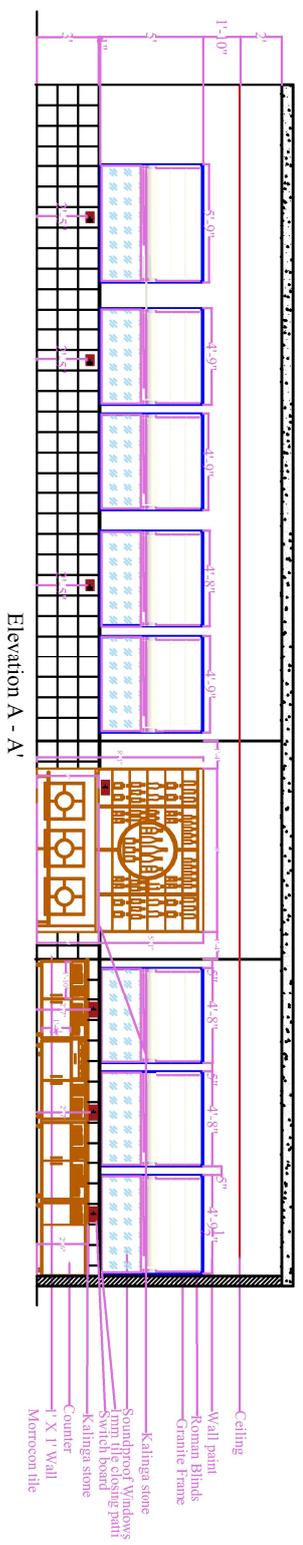

Elevation A - A'


- Ceiling
- Wall paint
- Roman Blinds
- Granite Frame
- Kalinga stone
- Soundproof Windows
- Joint tile closing path
- Switch board
- Kalinga stone
- Counter
- 1" X 1" Wall
- Moroccan tile





NOTE:  
1. All measurements are in feet and inches.

Description
Wall
Column
Window
Beam Line

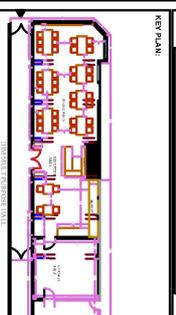

REV.	DATE	DESCRIPTION







Client:  
**Institute of Hotel Management,**  
Dadar west,  
Mumbai.


CONSULTANT:



Drawing Title:  
**IHM MULTIPURPOSE HALL**  
Details

Scale: Sheet 08

Drawn by: ANAYKHANA SHRODI	Checked by: GABRIELANG VORA	Approved by:	Date: 17.03.2018
Sheet No: 03	Revision:		

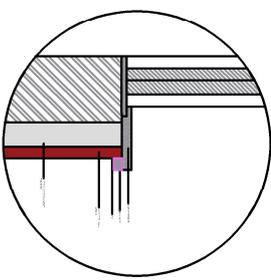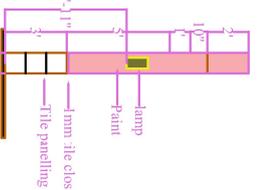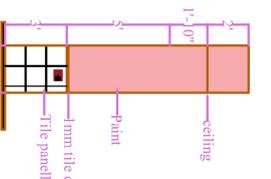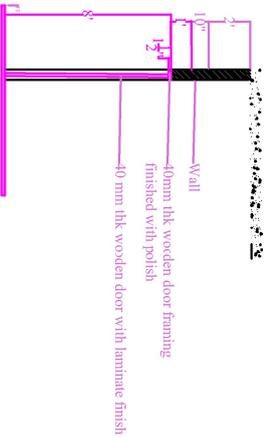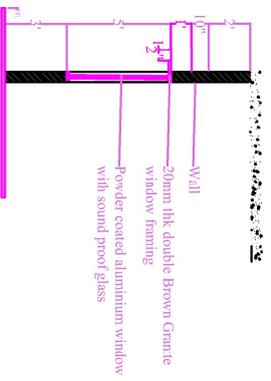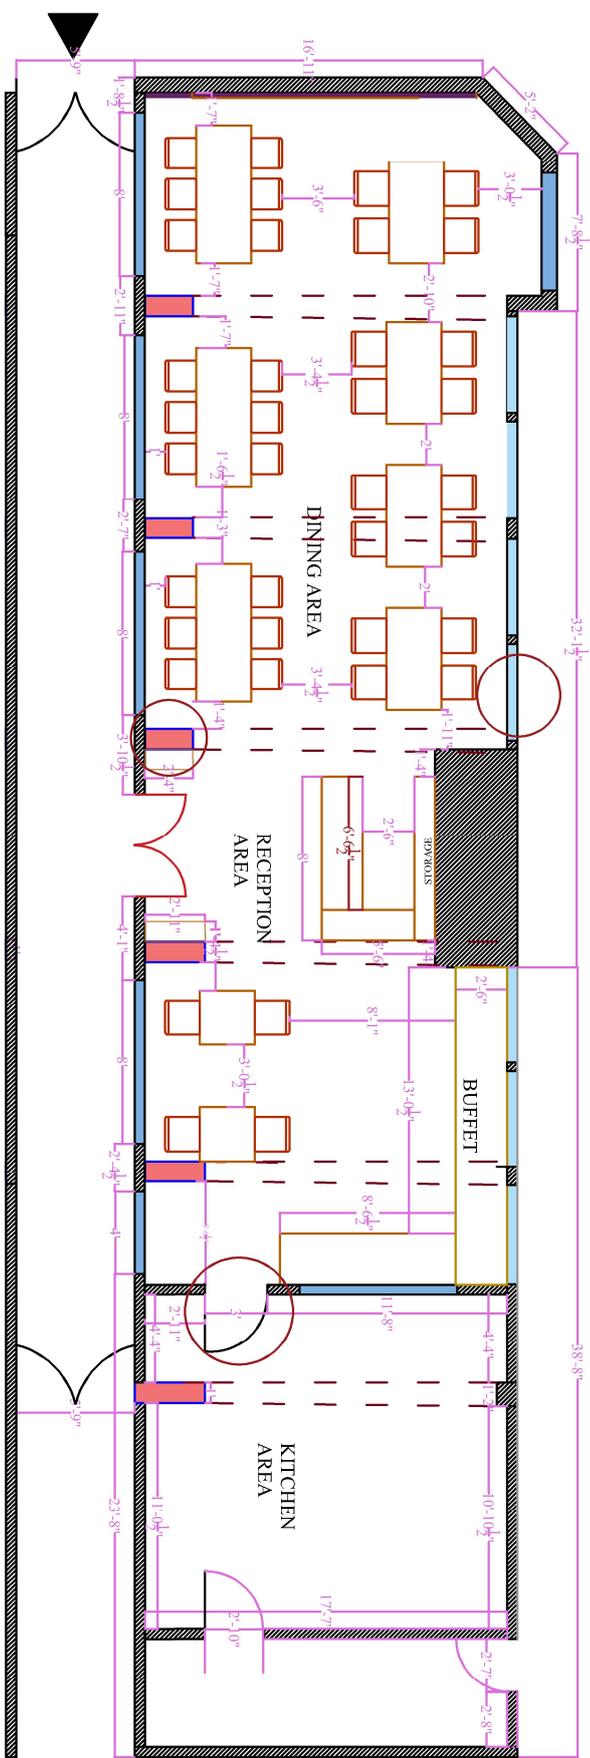

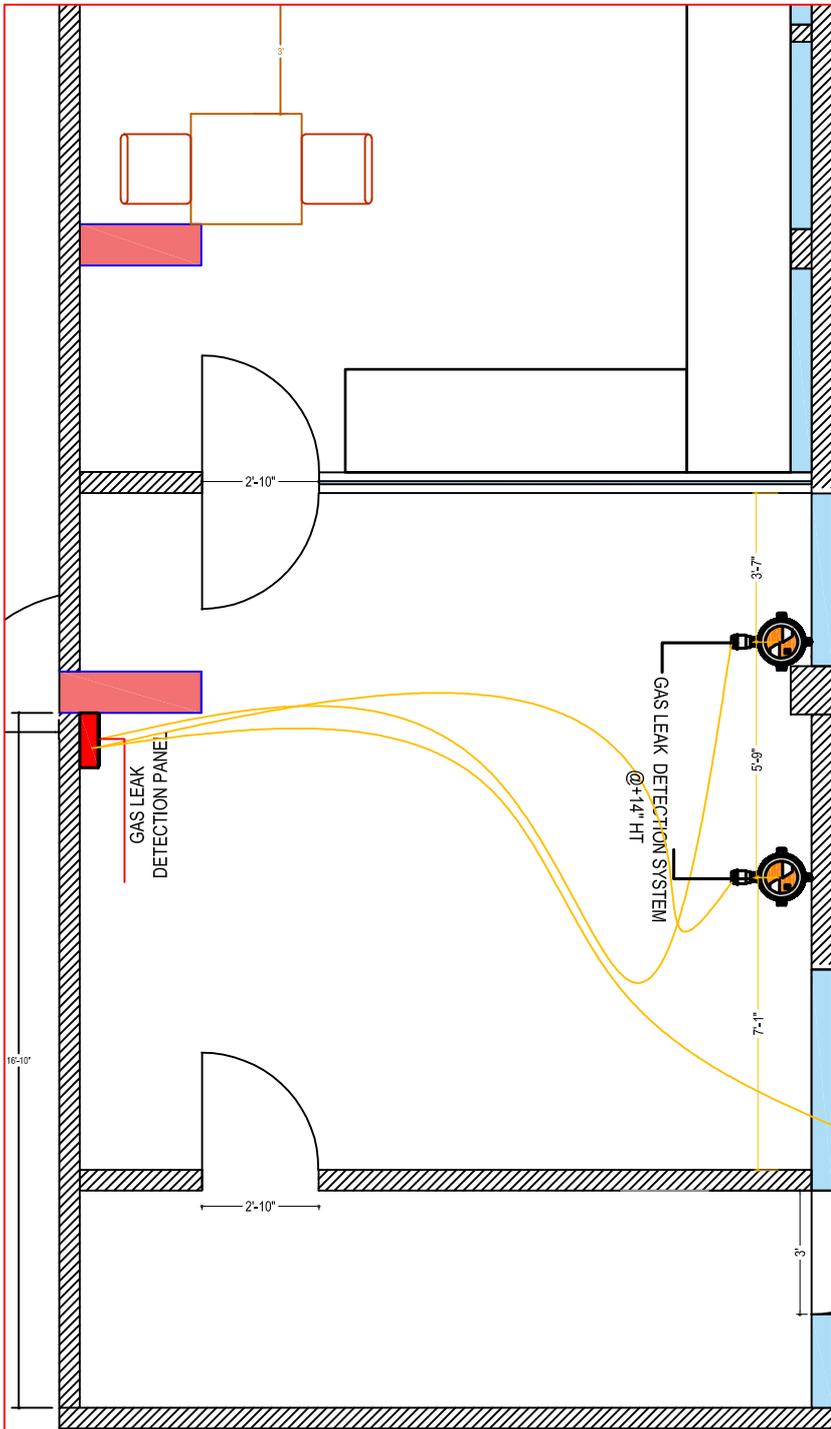


  LEAK DETECTION LEGEND	
	GAS LEAK DETECTION SYSTEM
	SOLONOID VALVE
	GAS LEAK DETECTION PANEL
	HOOTER
	1.5 sq. mm. X 4 CORE ARMoured CABLE
	GAS METER

RESTUARANT 1

DO NOT SCALE DRAWING COPYRIGHT OF.THIS DRAWING BELONGS TO S.A DESIGN

LEGENDS	CLIENT	PROJECT	DRAWING TITLE	DRAWN BY	CHECKED BY	SCALE N.T.S	 <b>S.A.DESIGN</b> F & B PLANNER & DESIGNER <small>GARDEN VIEW CHS LTD GALA NO 2 CS ROAD          DAHISAR E MUMBAI - 68 TEL :- 022 28964164</small>
	.....	IHM DADAR	GAS LEAK DETECTION LAYOUT	ANGELIN	SADANAND	DATE 20/03/2025	

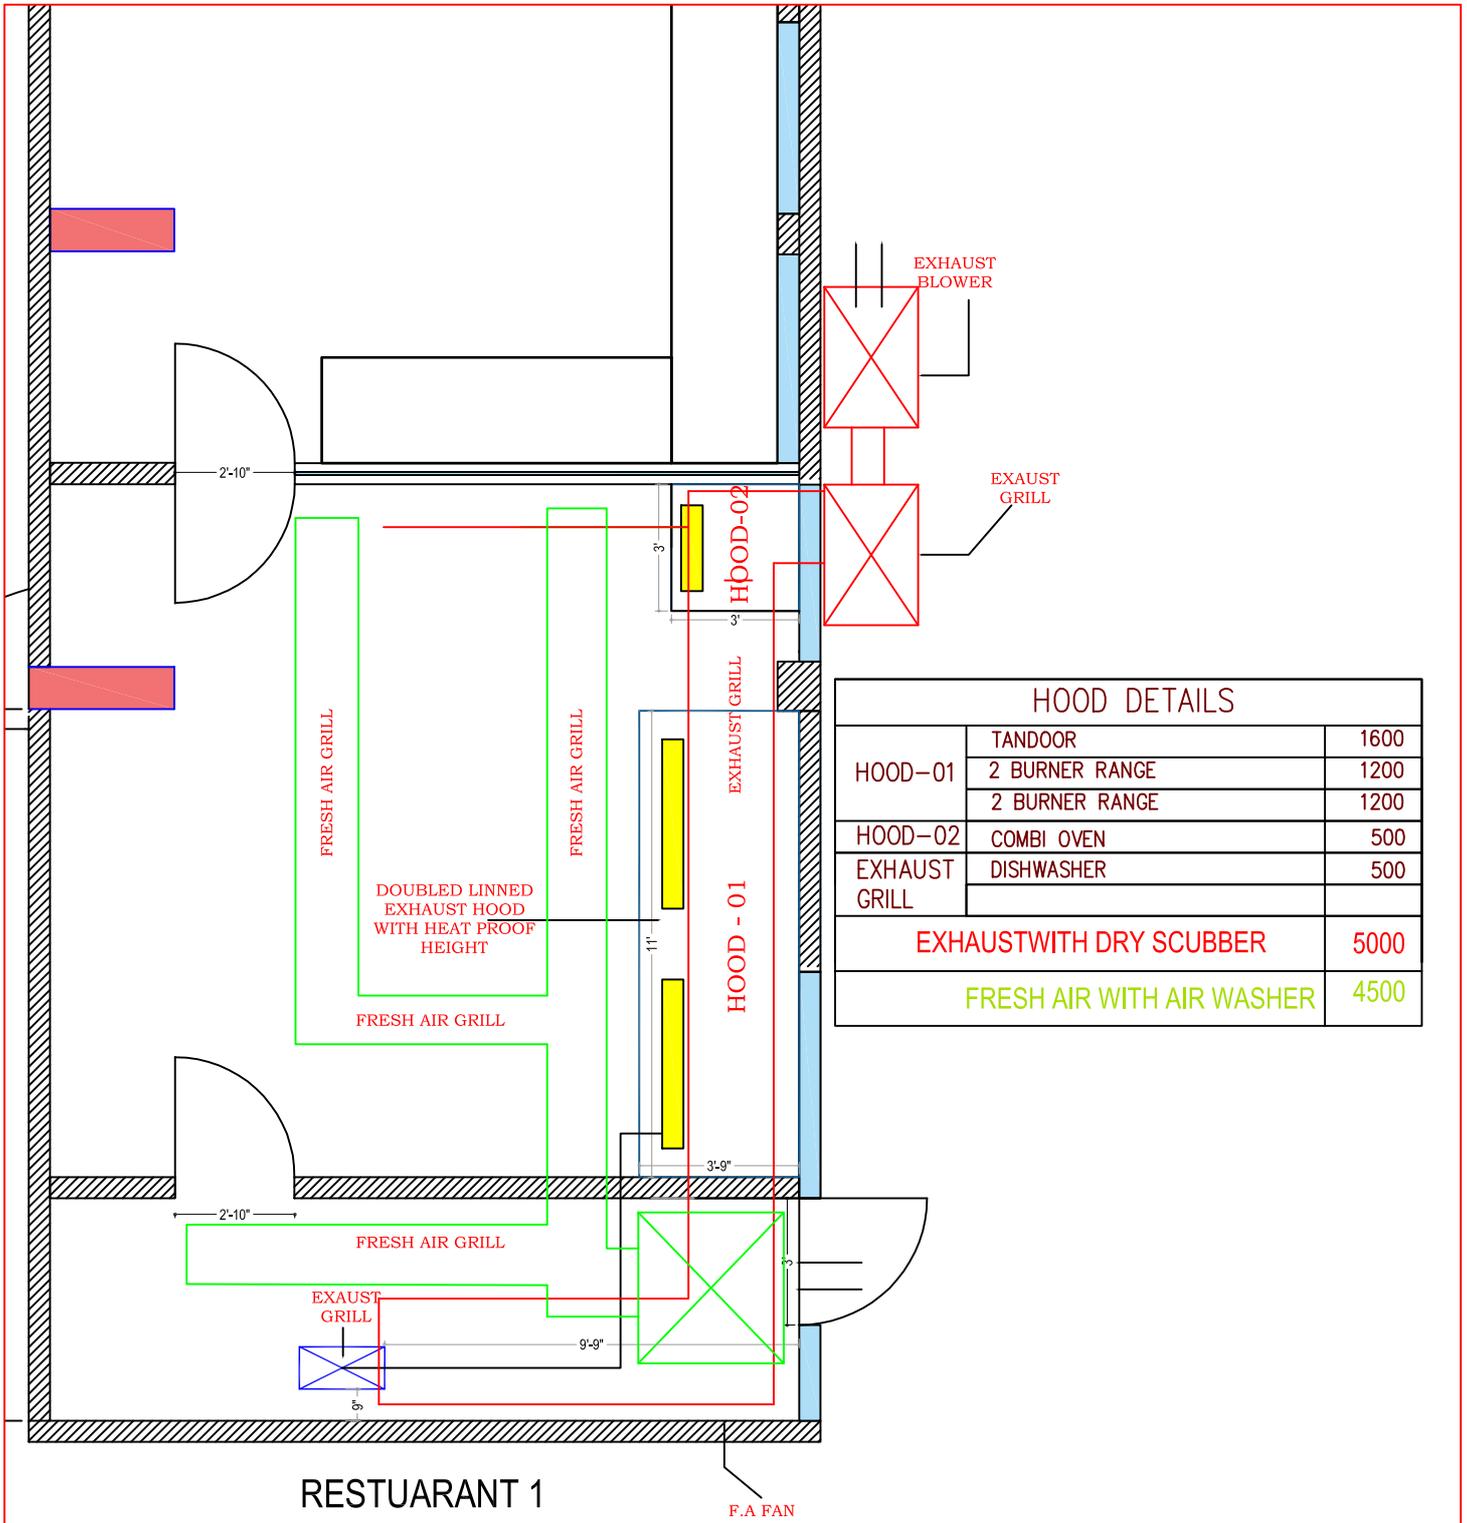

HOOD DETAILS		
HOOD-01	TANDOOR	1600
	2 BURNER RANGE	1200
	2 BURNER RANGE	1200
HOOD-02	COMBI OVEN	500
EXHAUST GRILL	DISHWASHER	500
EXHAUST WITH DRY SCUBBER		5000
FRESH AIR WITH AIR WASHER		4500


RESTUARANT 1

F.A FAN

DO NOT SCALE DRAWING COPYRIGHT OF THIS DRAWING BELONGS TO S.A DESIGN


LEGENDS	CLIENT	PROJECT	DRAWING TITLE	DRAWN BY	CHECKED BY	SCALE N.T.S	 <b>S.A.DESIGN</b> F & B PLANNER & DESIGNER <small>GARDEN VIEW CHS LTD GALA NO 2 CS ROAD DAHISAR E MUMBAI - 68 TEL :- 022 28964164</small>
	.....	IHM DADAR	HOOD LAYOUT	ANGELIN	SADANAND	20/03/2025	



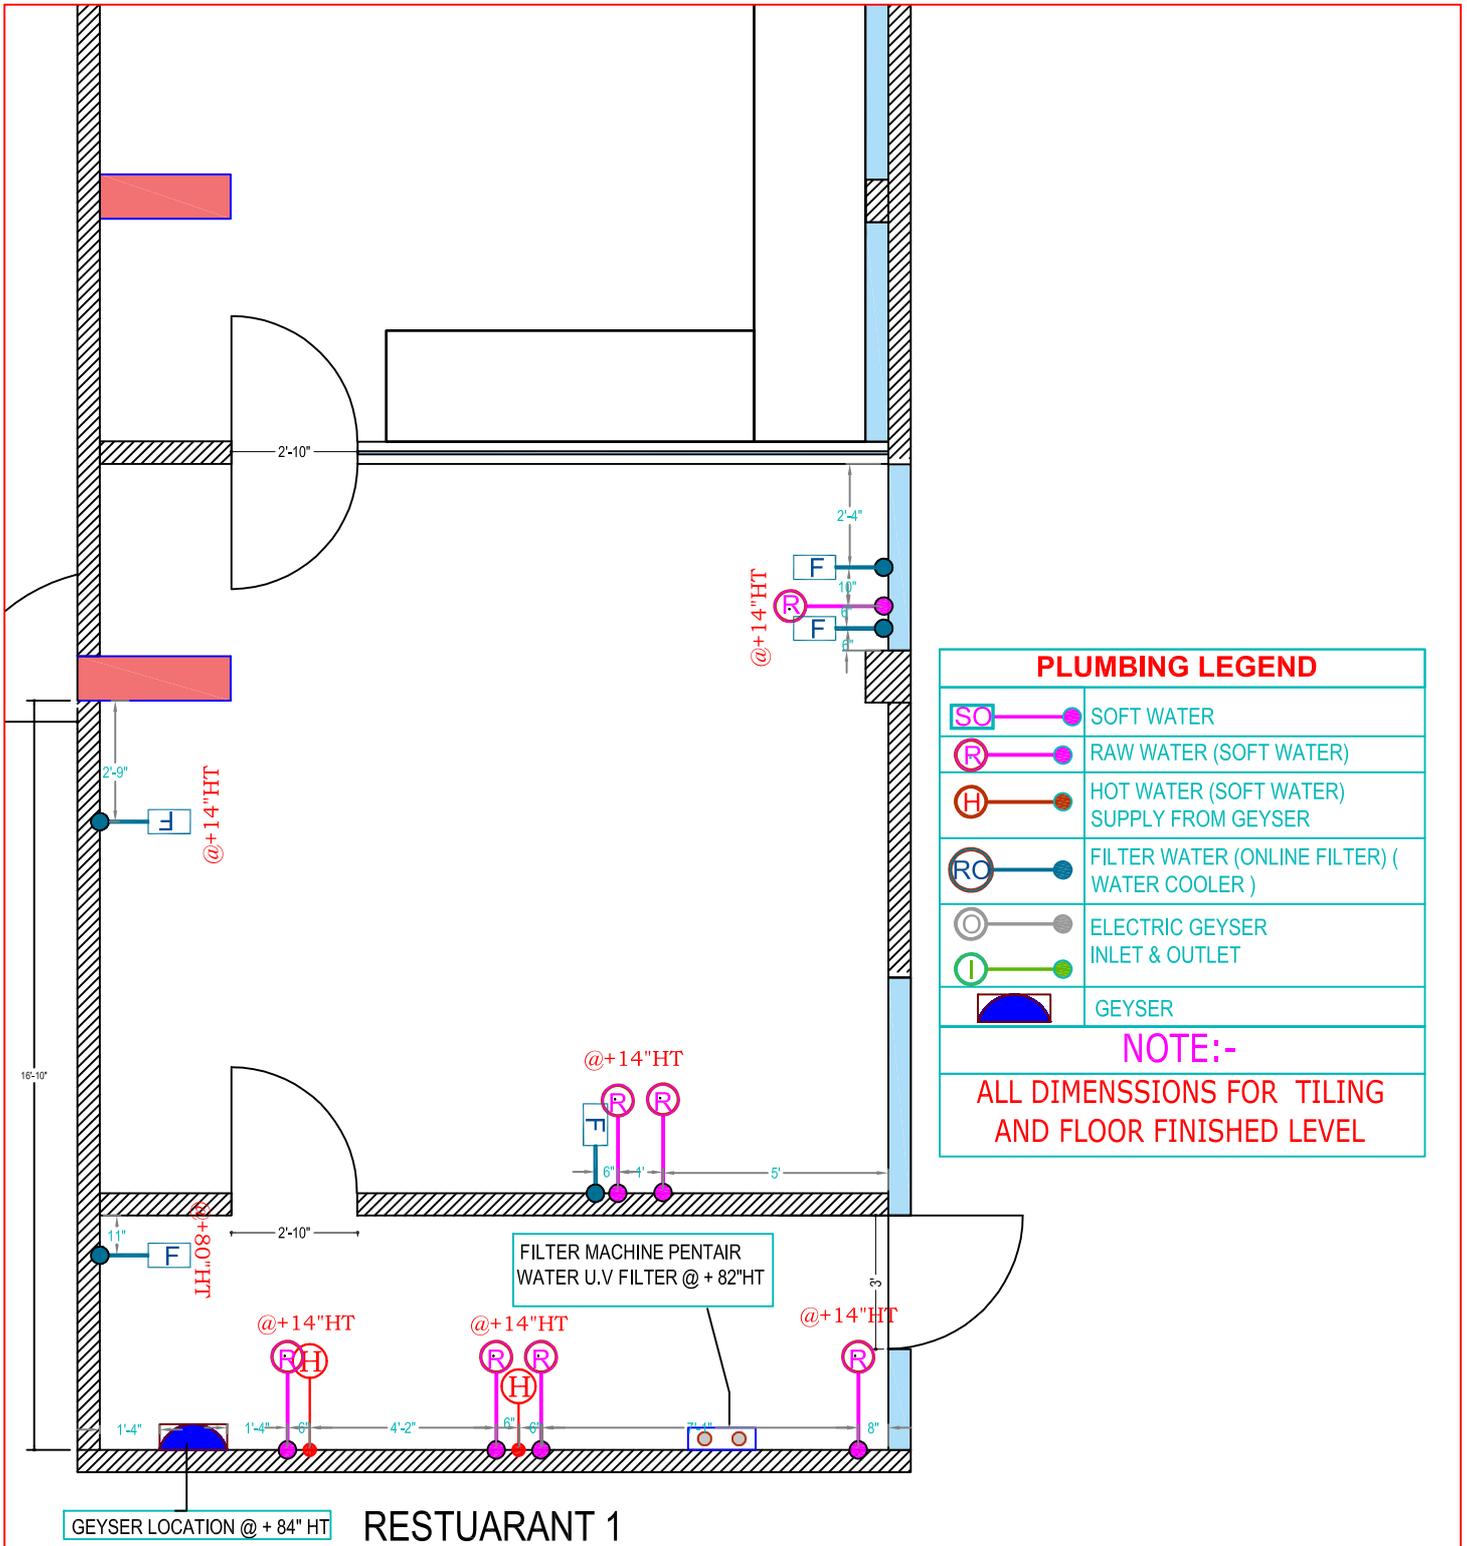



DO NOT SCALE DRAWING COPYRIGHT OF THIS DRAWING BELONGS TO S.A DESIGN

LEGENDS	CLIENT	PROJECT	DRAWING TITLE	DRAWN BY	CHECKED BY	SCALE N.T.S	 <b>S.A.DESIGN</b> F & B PLANNER & DESIGNER <small>GARDEN VIEW CHS LTD GALA NO 2 CS ROAD          DAHISAR E MUMBAI - 68 TEL :- 022 28964164</small>
	.....	IHM DADAR	PLUMBING LAYOUT	ANGELIN	SADANAND	DATE 17/03/2025	

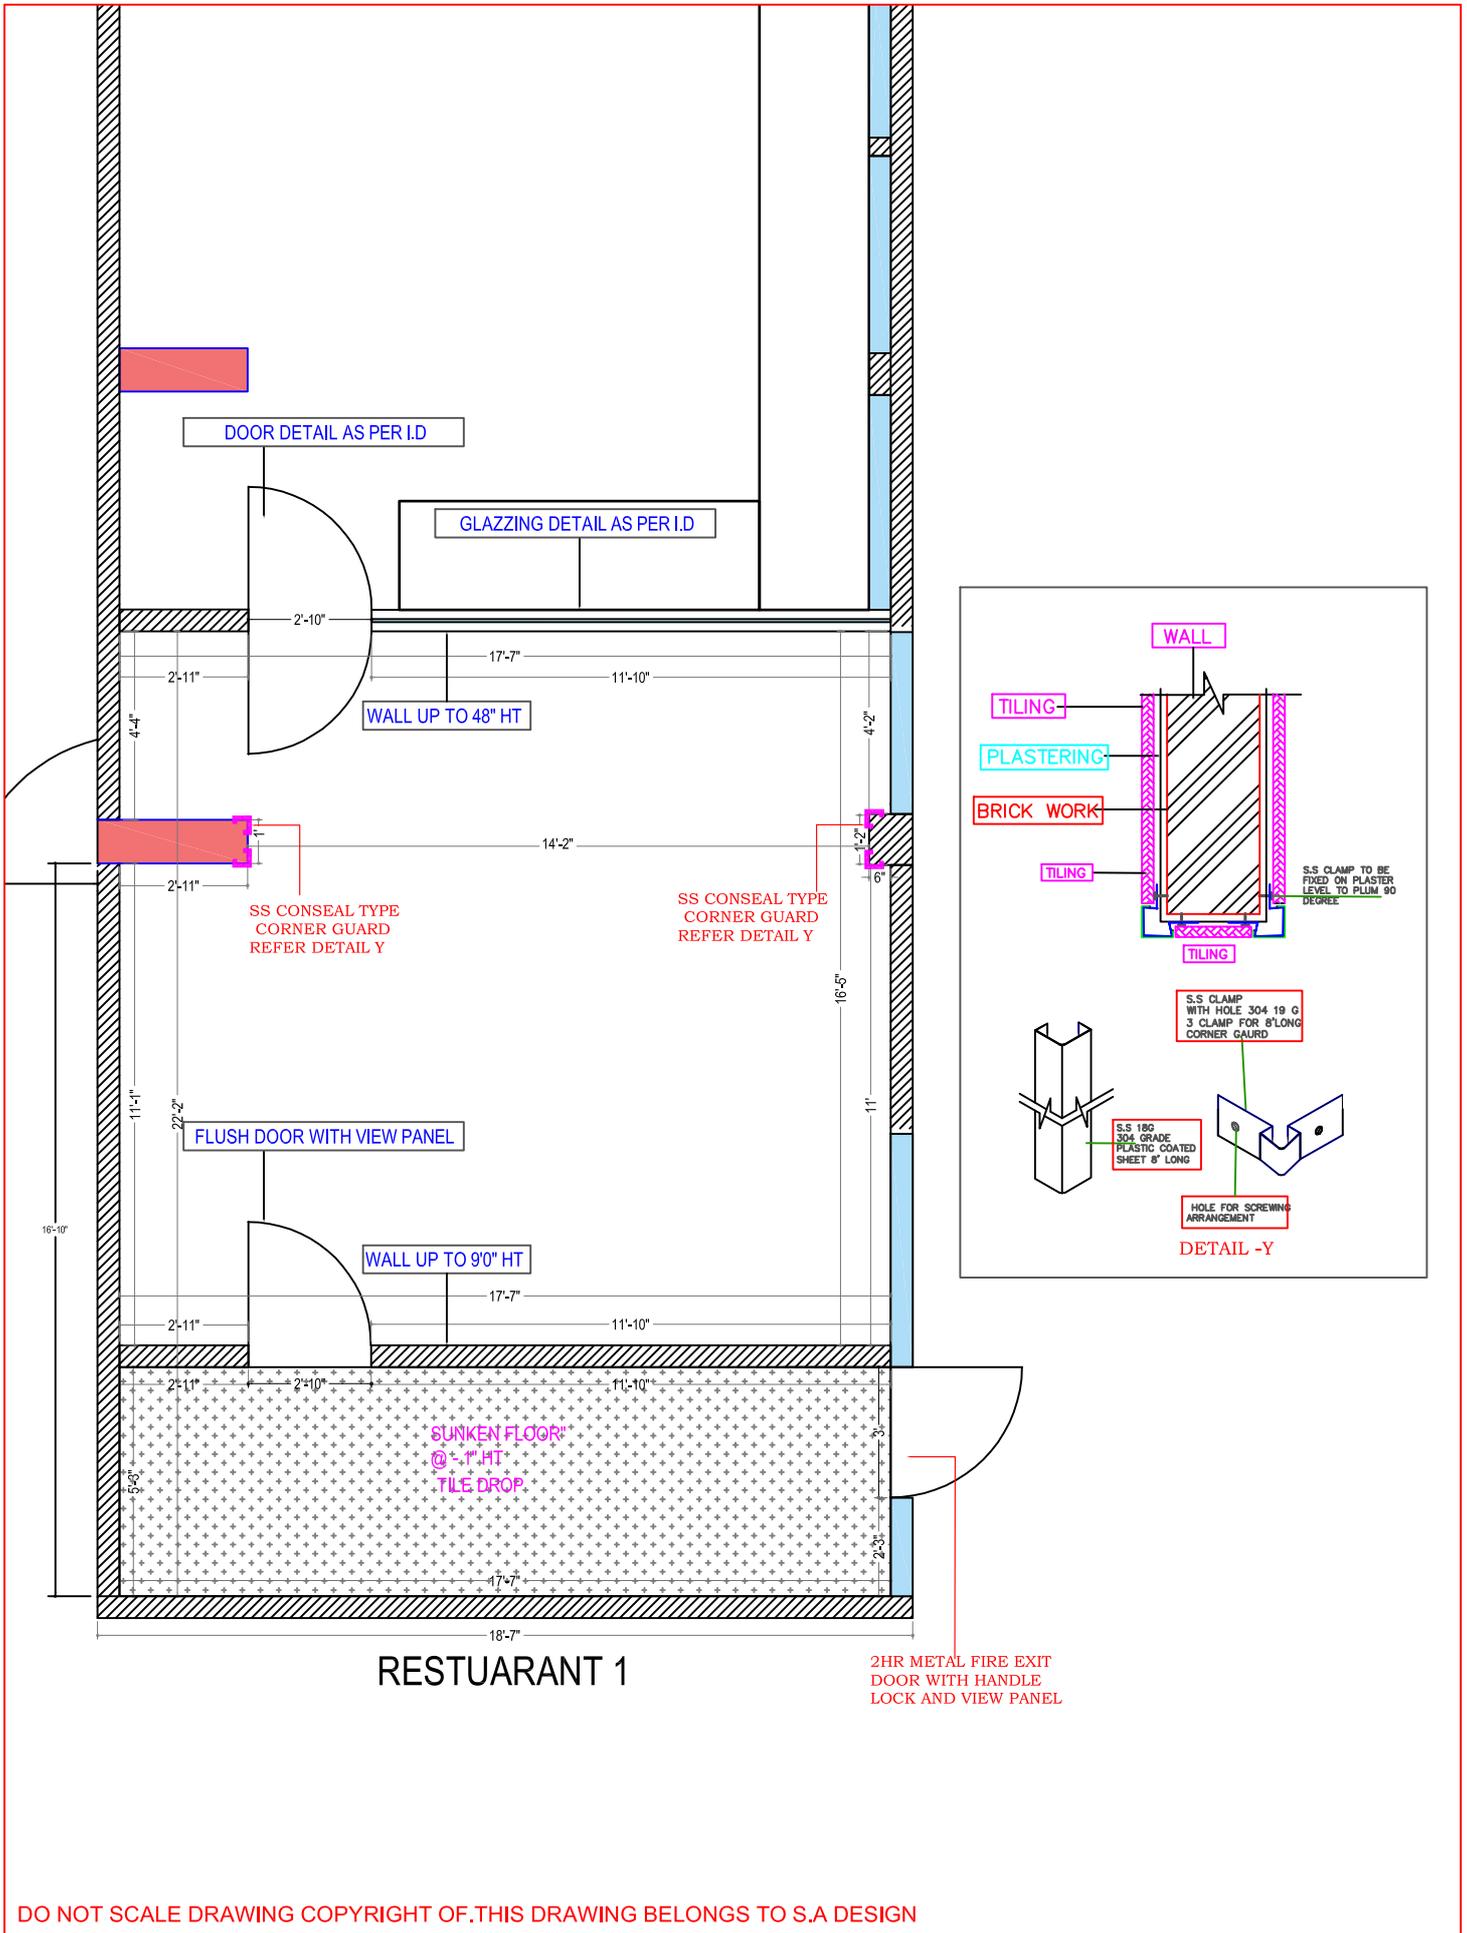

DO NOT SCALE DRAWING COPYRIGHT OF THIS DRAWING BELONGS TO S.A DESIGN

LEGENDS	CLIENT	PROJECT	DRAWING TITLE	DRAWN BY	CHECKED BY	SCALE N.T.S	 <b>S.A.DESIGN</b> F & B PLANNER & DESIGNER <small>GARDEN VIEW CHS LTD GALA NO 2 CS ROAD DAHISAR E MUMBAI - 68 TEL :- 022 28964164</small>
	.....	IHM DADAR	CIVIL LAYOUT	ANGELIN	SADANAND	DATE 20/03/2025	

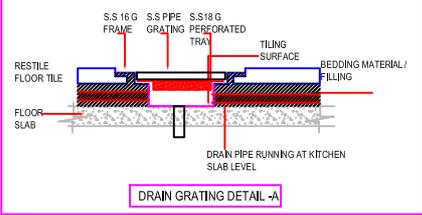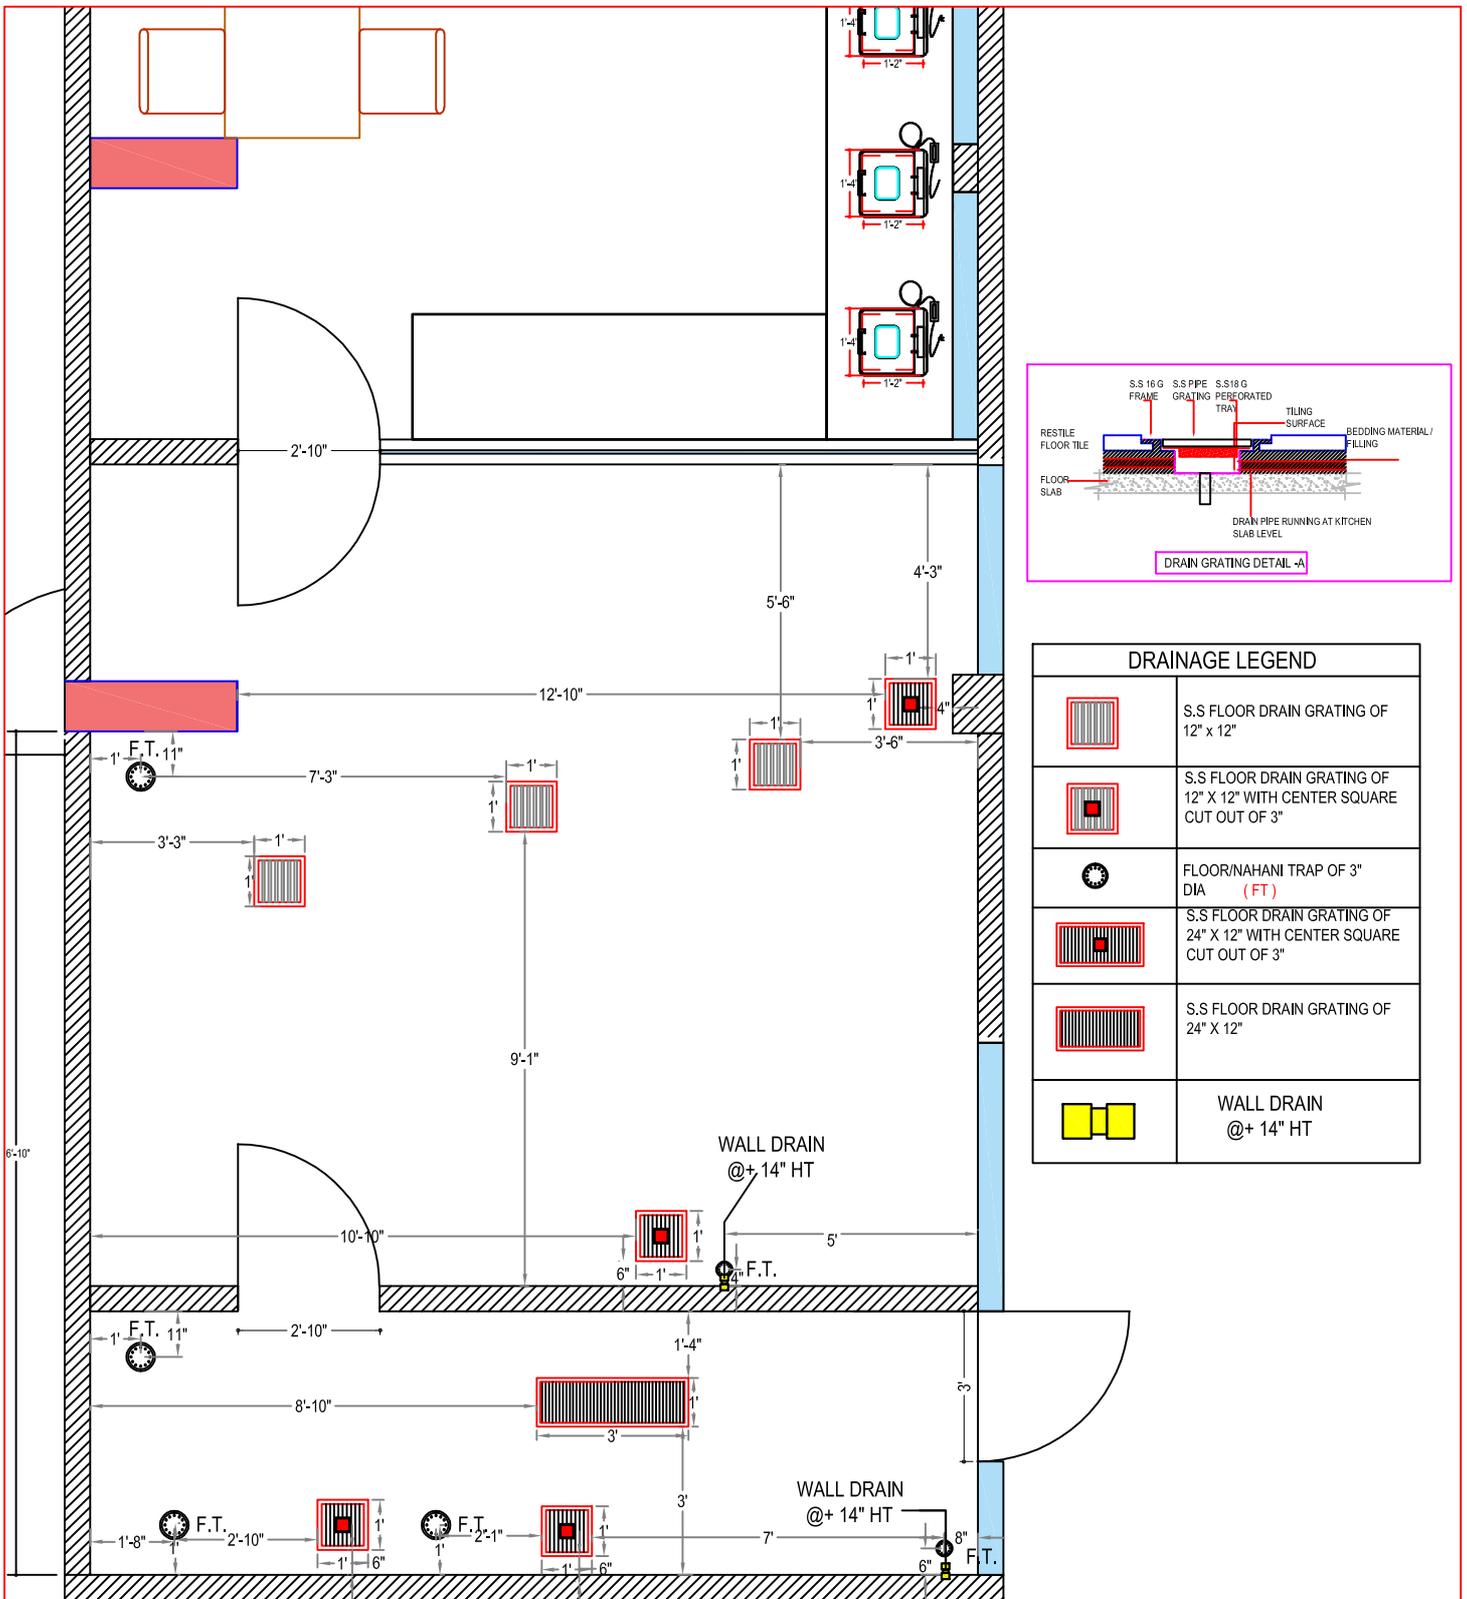


DRAINAGE LEGEND	
	S.S FLOOR DRAIN GRATING OF 12" X 12"
	S.S FLOOR DRAIN GRATING OF 12" X 12" WITH CENTER SQUARE CUT OUT OF 3"
	FLOOR/NAHANI TRAP OF 3" DIA (FT)
	S.S FLOOR DRAIN GRATING OF 24" X 12" WITH CENTER SQUARE CUT OUT OF 3"
	S.S FLOOR DRAIN GRATING OF 24" X 12"
	WALL DRAIN @+ 14" HT

# RESTUARANT 1

DO NOT SCALE DRAWING COPYRIGHT OF.THIS DRAWING BELONGS TO S.A DESIGN

LEGENDS	CLIENT	PROJECT	DRAWING TITLE	DRAWN BY	CHECKED BY	SCALE N.T.S	<b>S.A.DESIGN</b> F & B PLANNER & DESIGNER <small>GARDEN VIEW CHS LTD GALA NO 2 CS ROAD DAHISAR E MUMBAI - 68 TEL :- 022 28964164</small>
	.....	IHM DADAR	DRAINAGE LAYOUT	ANGELIN	SADANAND	20/03/2025	






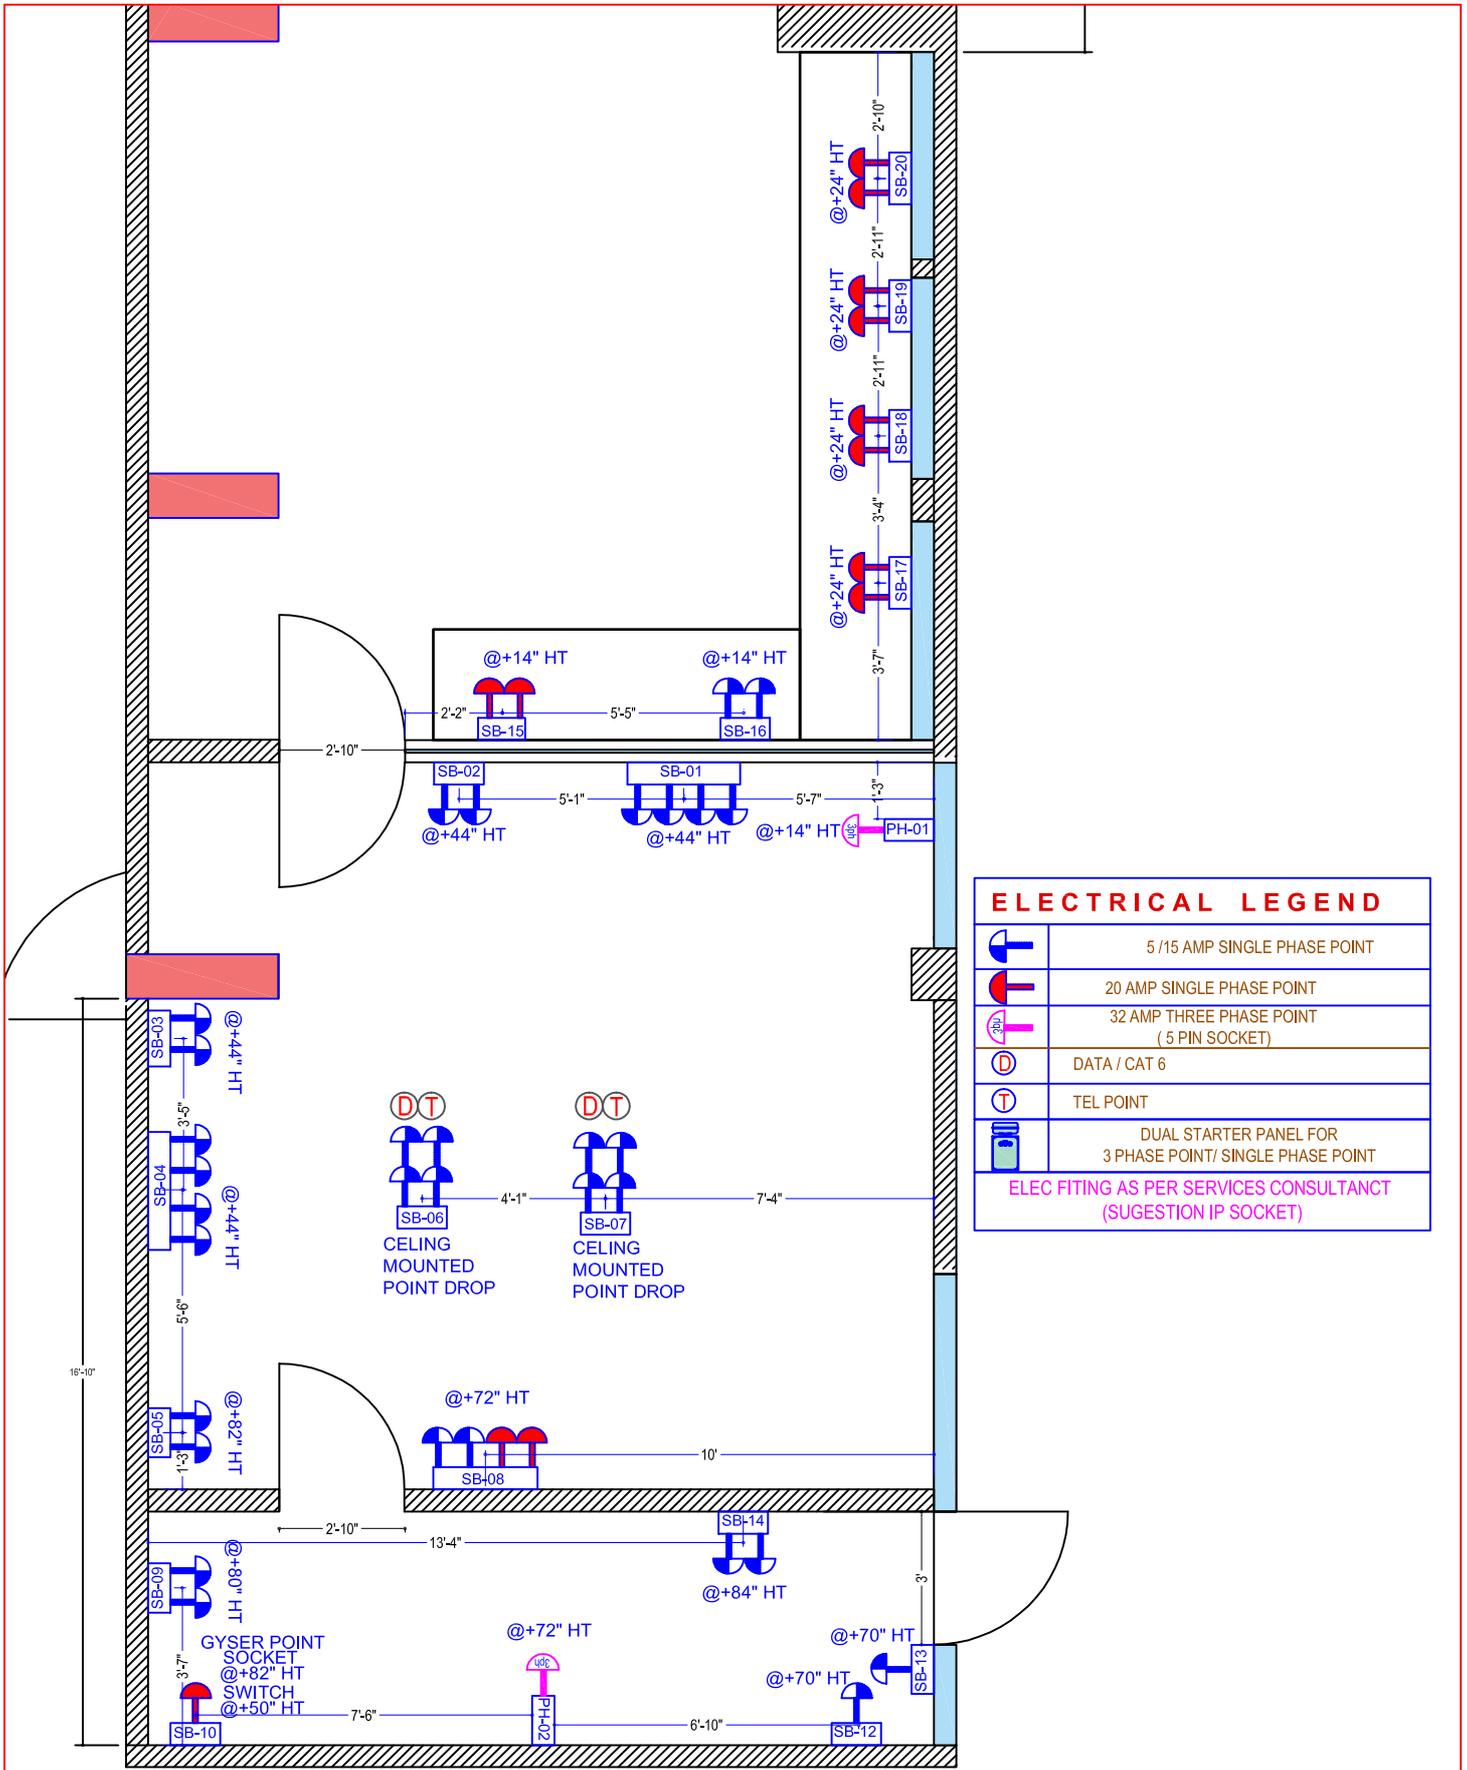


ELECTRICAL LEGEND	
	5 /15 AMP SINGLE PHASE POINT
	20 AMP SINGLE PHASE POINT
	32 AMP THREE PHASE POINT (5 PIN SOCKET)
	DATA / CAT 6
	TEL POINT
	DUAL STARTER PANEL FOR 3 PHASE POINT/ SINGLE PHASE POINT
ELEC FITING AS PER SERVICES CONSULTANCT (SUGESTION IP SOCKET)	

## RESTUARANT 1


DO NOT SCALE DRAWING COPYRIGHT OF.THIS DRAWING BELONGS TO S.A DESIGN

LEGENDS	CLIENT	PROJECT	DRAWING TITLE	DRAWN BY	CHECKED BY	SCALE N.T.S	 <b>S.A.DESIGN</b> F & B PLANNER & DESIGNER <small>GARDEN VIEW CHS LTD GALA NO 2 CS ROAD          DAHISAR E MUMBAI - 68 TEL :- 022 28964164</small>
	.....	IHM DADAR	ELECTRICAL LAYOUT	ANGELIN	SADANAND	20/03/2025	

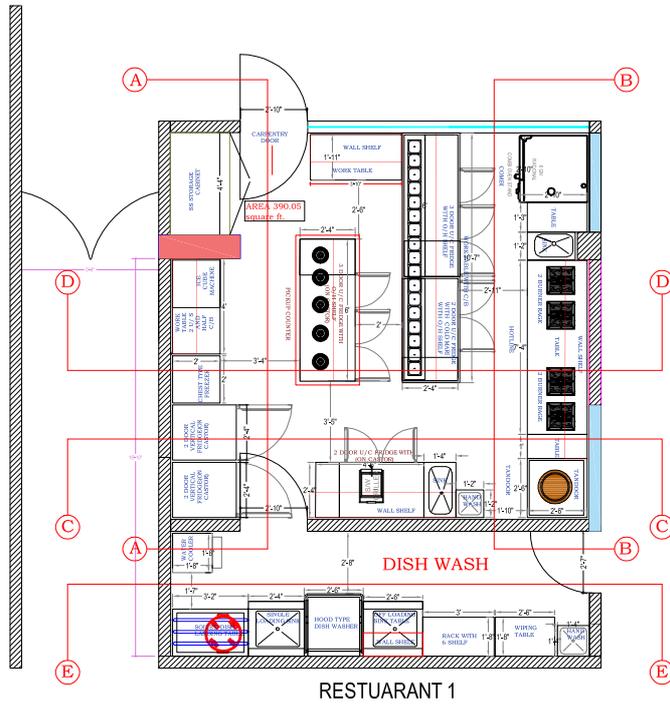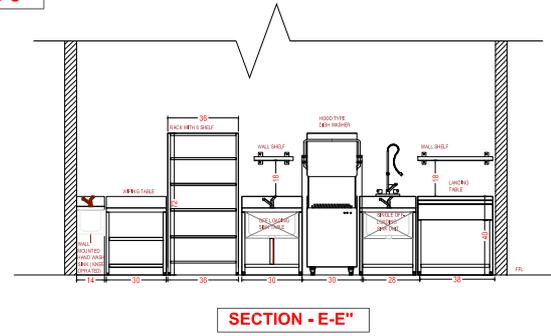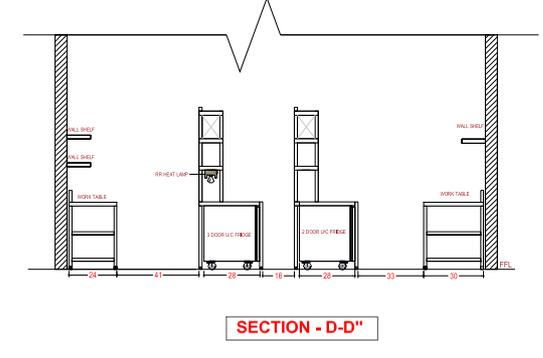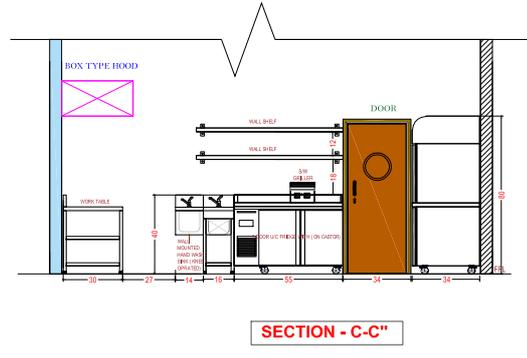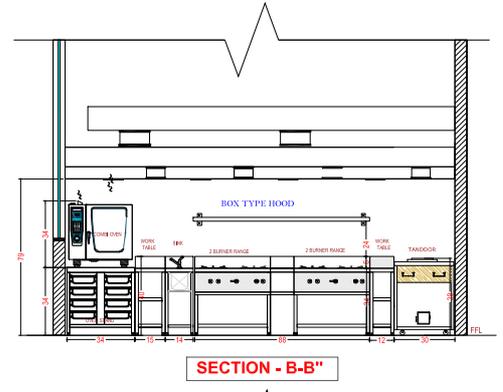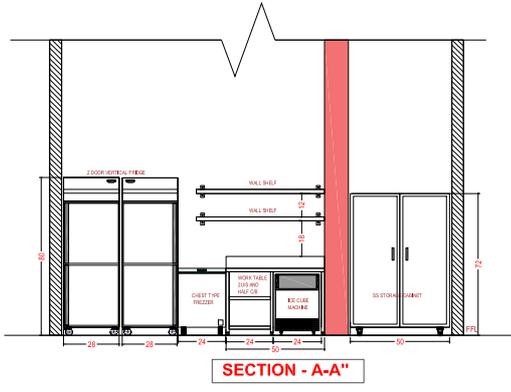

DO NOT SCALE DRAWING COPYRIGHT OF THIS DRAWING BELONGS TO S.A DESIGN


LEGENDS	CLIENT	PROJECT	DRAWING TITLE	DRAWN BY	CHECKED BY	SCALE N.T.S	 <b>S.A.DESIGN</b> F & B PLANNER & DESIGNER <small>GARDEN VIEW CHS LTD GALA NO 2 CS ROAD DAHISAR E MUMBAI - 68 TEL : - 022 28964164</small>
	.....	IHM DADAR	ELEVATION LAYOUT	ANGELIN	SADANAND	DATE 26/03/2025	

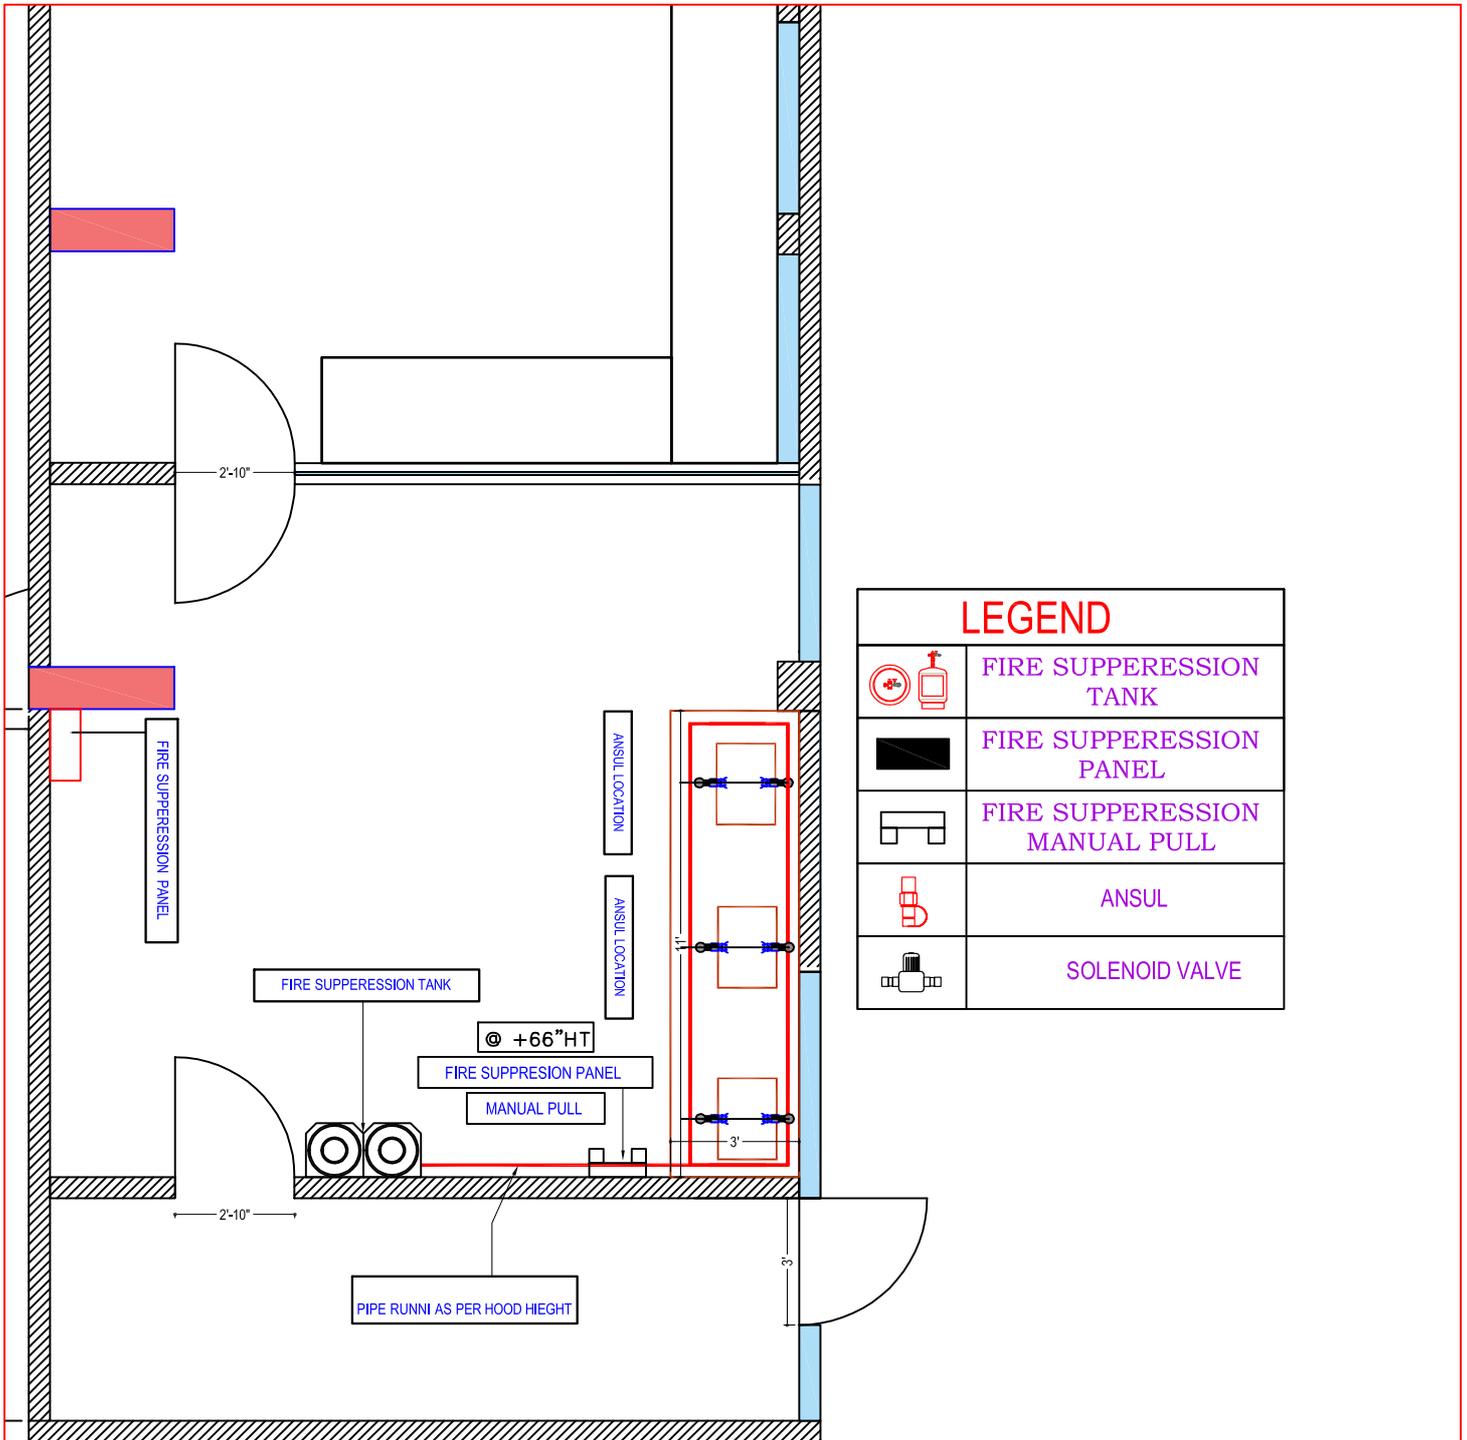

LEGEND	
	FIRE SUPPRESSION TANK
	FIRE SUPPRESSION PANEL
	FIRE SUPPRESSION MANUAL PULL
	ANSUL
	SOLENOID VALVE


DO NOT SCALE DRAWING COPYRIGHT OF THIS DRAWING BELONGS TO S.A DESIGN

LEGENDS	CLIENT	PROJECT	DRAWING TITLE	DRAWN BY	CHECKED BY	SCALE N.T.S	 <b>S.A.DESIGN</b> F & B PLANNER & DESIGNER <small>GARDEN VIEW CHS LTD GALA NO 2 CS ROAD          DAHISAR E MUMBAI - 68 TEL :- 022 28964164</small>
	.....	IHM DADAR	FIRE SUPPRESSION LAYOUT	ANGELIN	SADANAND	DATE 20/03/2025	

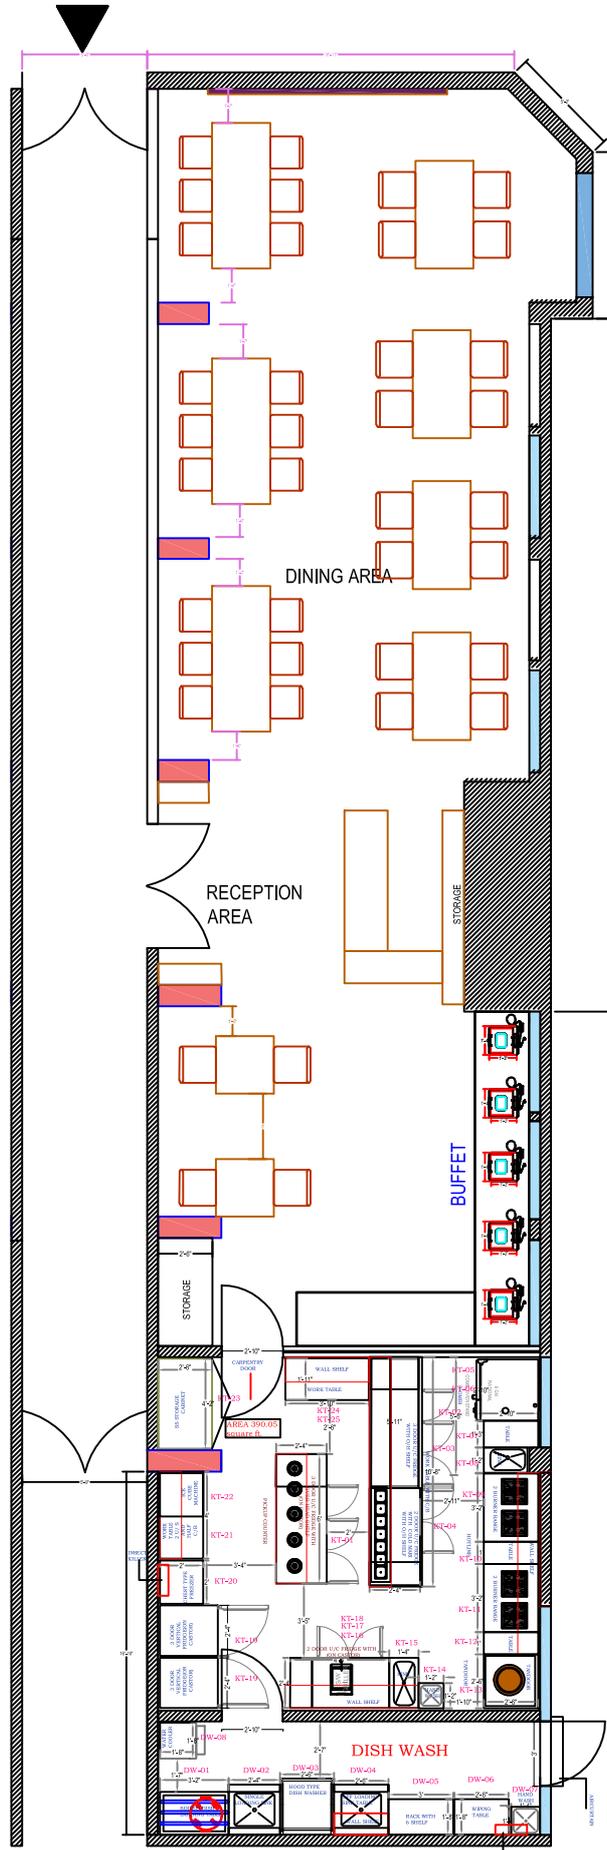

DO NOT SCALE DRAWING COPYRIGHT OF THIS DRAWING BELONGS TO SA DESIGN

LEGENDS	CLIENT	PROJECT	DRAWING TITLE	DRAWN BY	CHECKED BY	SCALE N.T.S	 <b>S.A. DESIGN</b> F & B PLANNER & DESIGNER <small>GARDEN VIEW CHS LTD GALA NO 2 CS ROAD          DAHISAR E MUMBAI - 68 TEL :- 022 28964164</small>
	.....	IHM DADAR	FLOOR LAYOUT	ANGELIN	SADANAND	DATE 06/03/2025	

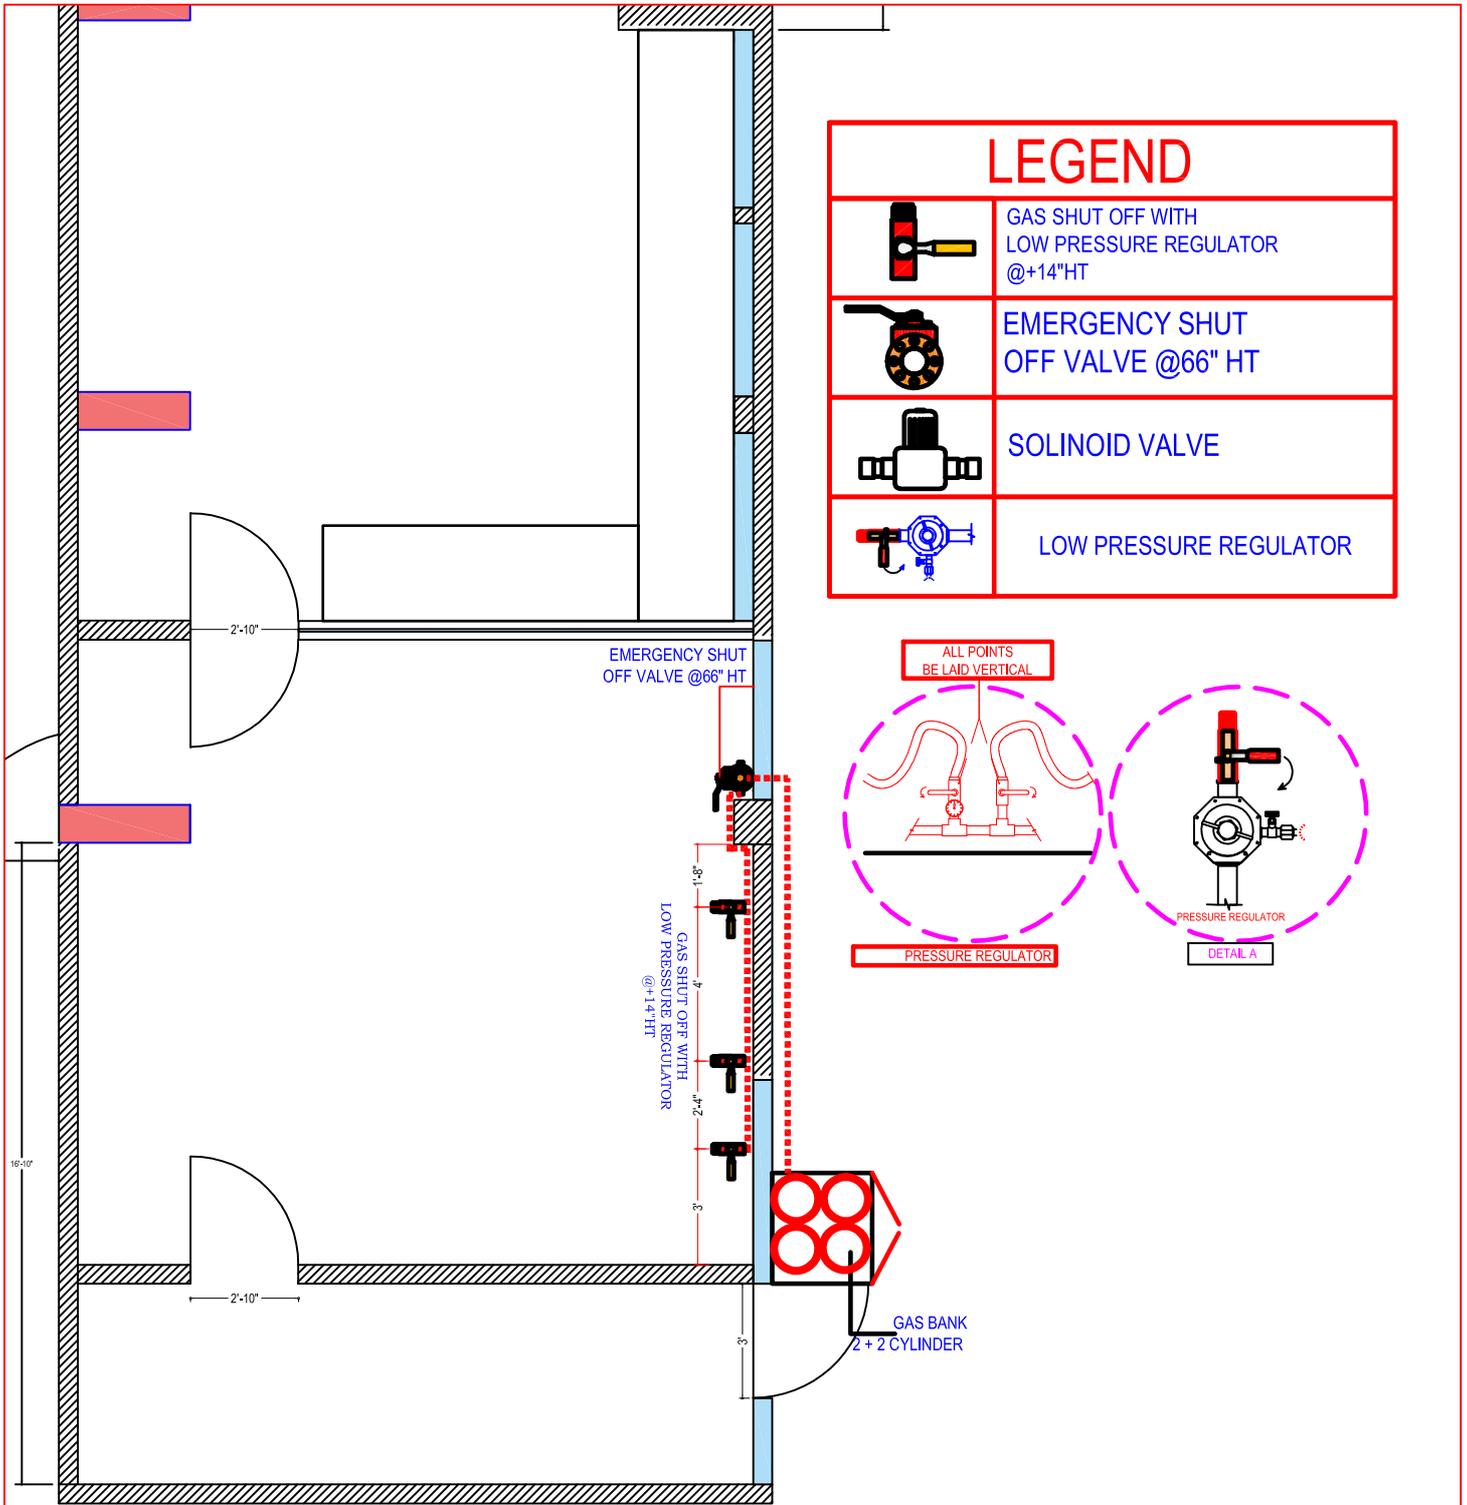

RESTUARANT 1

DO NOT SCALE DRAWING COPYRIGHT OF THIS DRAWING BELONGS TO S.A DESIGN

LEGENDS	CLIENT	PROJECT	DRAWING TITLE	DRAWN BY	CHECKED BY	SCALE N.T.S	 <b>S.A.DESIGN</b> F & B PLANNER & DESIGNER <small>GARDEN VIEW CHS LTD GALA NO 2 CS ROAD          DAHISAR E MUMBAI - 68 TEL :- 022 28964164</small>
	.....	IHM DADAR	GAS LAYOUT	ANGELIN	SADANAND	DATE 20/03/2025	